
 


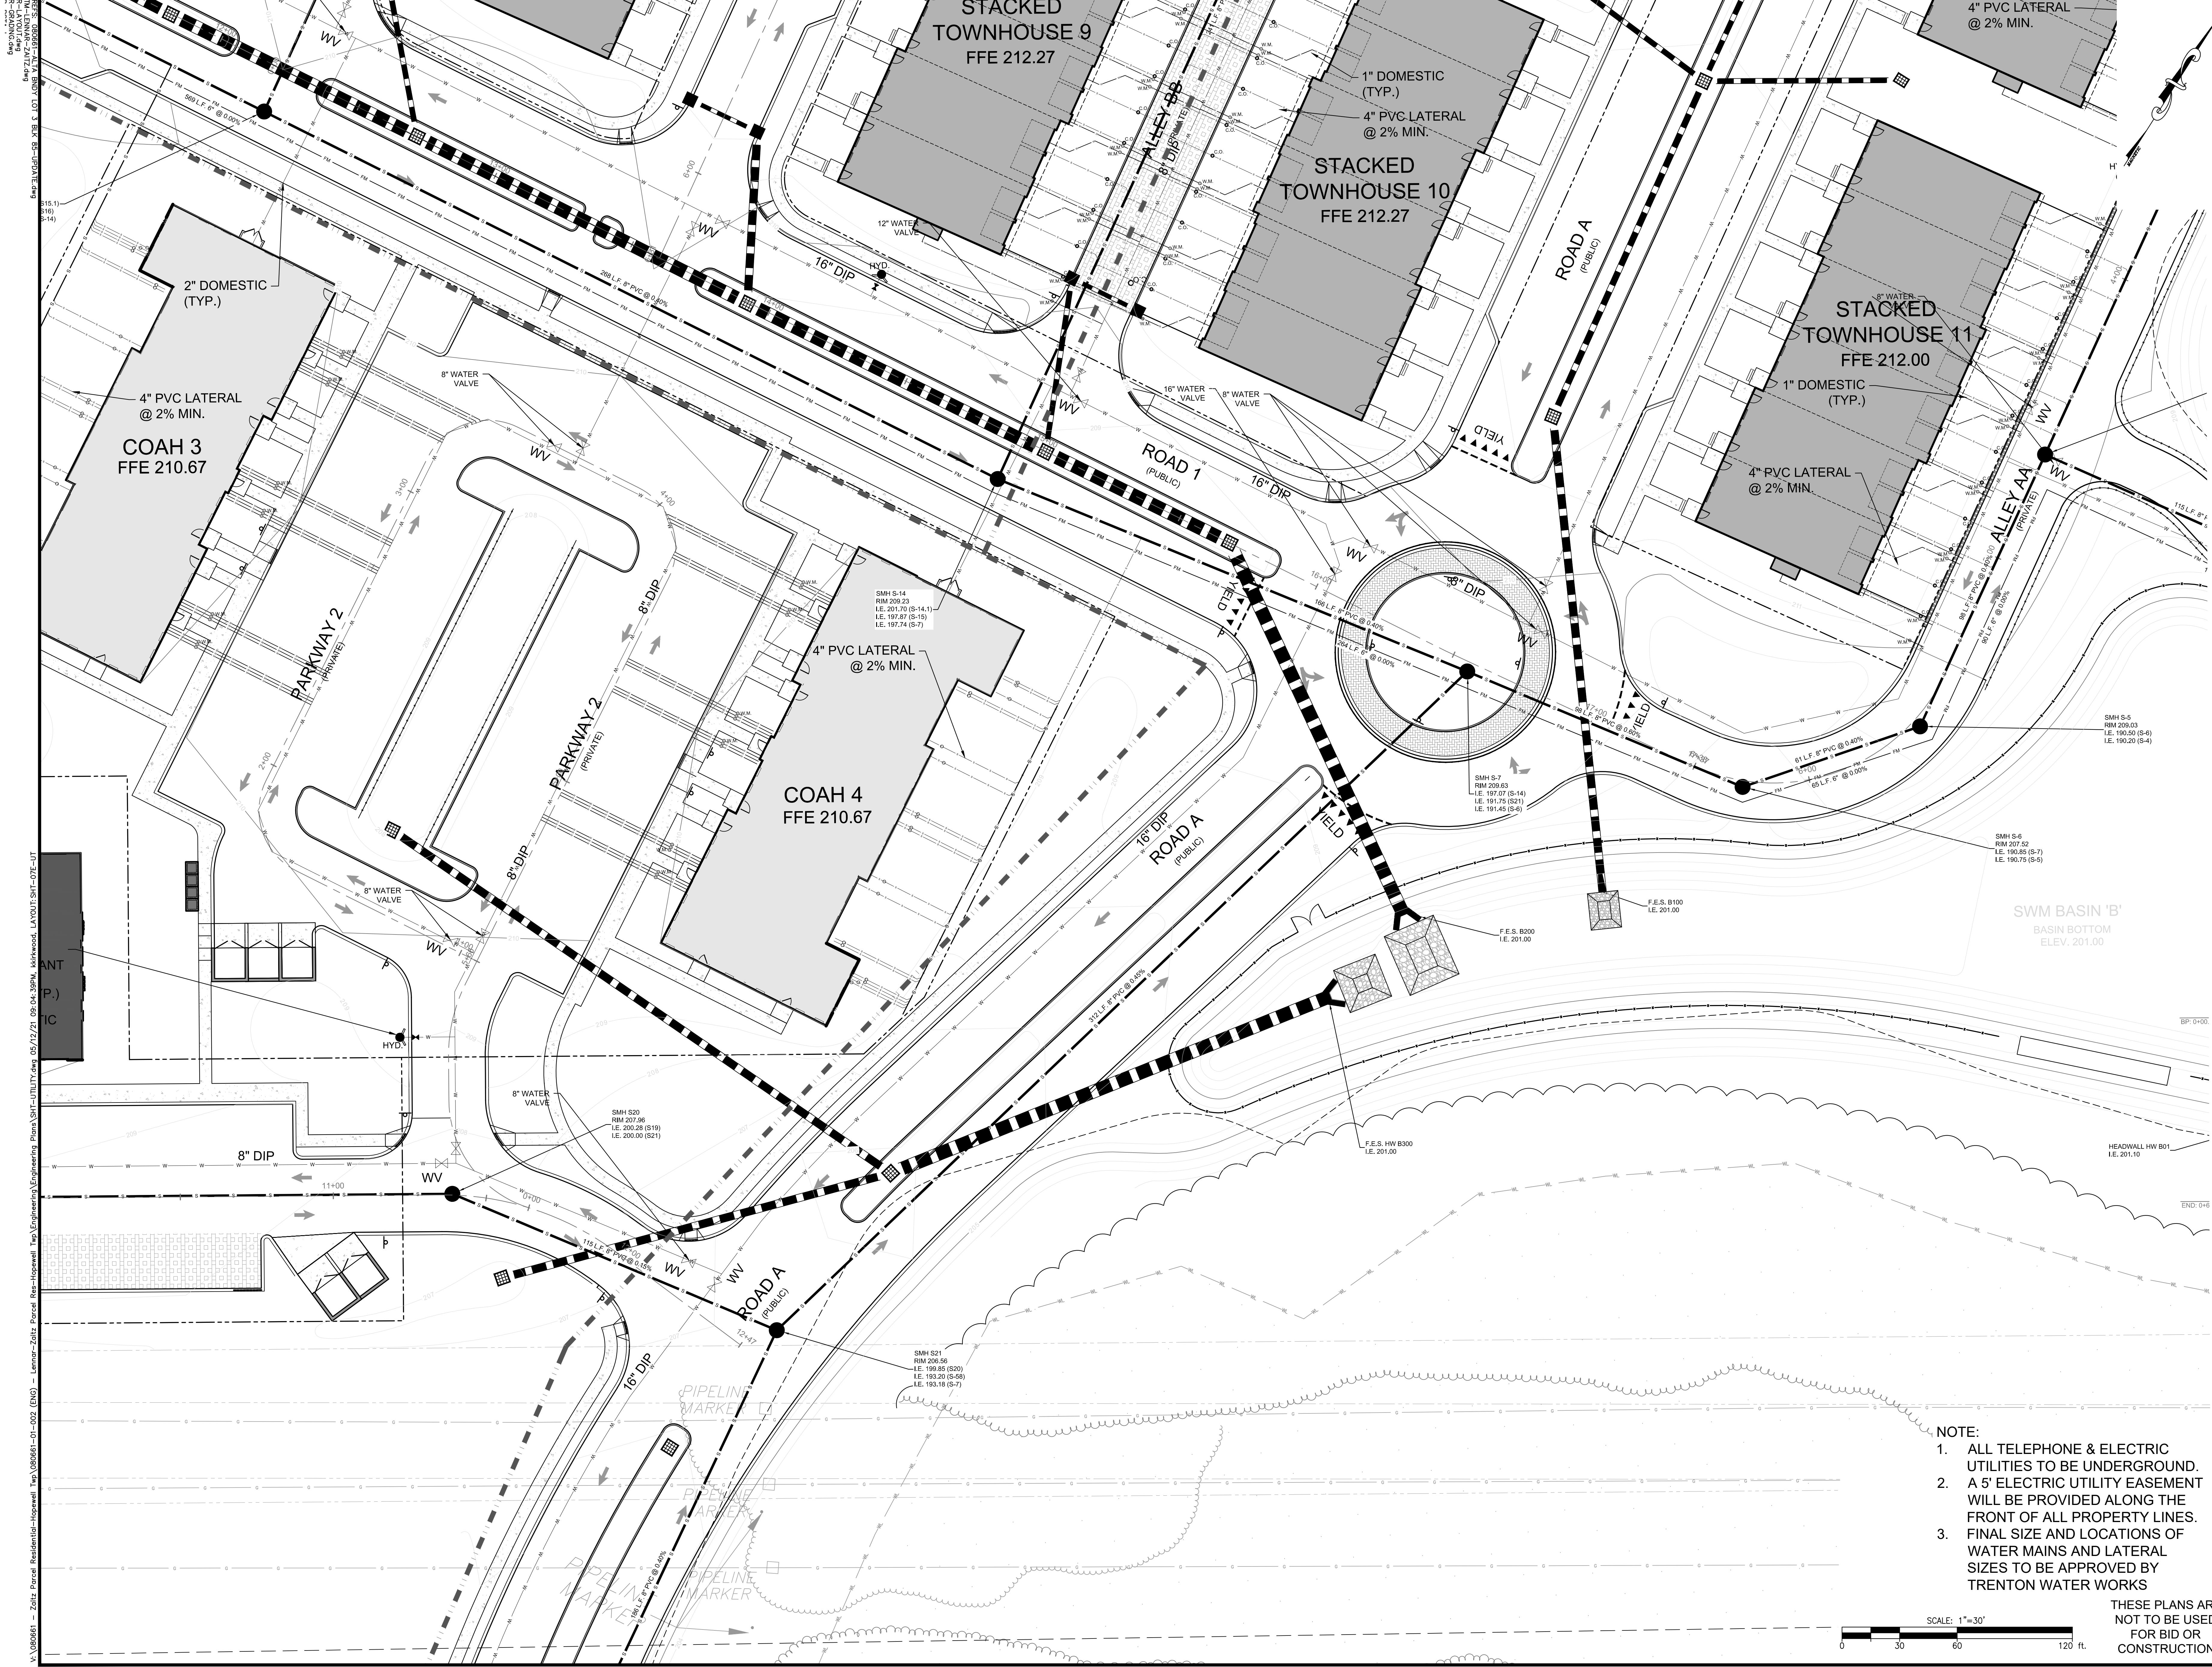

- NOTE:
1. ALL TELEPHONE & ELECTRIC UTILITIES TO BE UNDERGROUND.
 2. A 5' ELECTRIC UTILITY EASEMENT WILL BE PROVIDED ALONG THE FRONT OF ALL PROPERTY LINES.
 3. FINAL SIZE AND LOCATIONS OF WATER MAINS AND LATERAL SIZES TO BE APPROVED BY TRENTON WATER WORKS



THESE PLANS ARE
NOT TO BE USED
FOR BID OR
CONSTRUCTION

PROJ.: 08061-F-001
DATE: 1-20-2020
THIS DRAWING AND ALL INFORMATION CONTAINED HEREIN ARE THE PROPERTY OF BOWMAN CONSULTING. NO PART OF THIS DRAWING IS TO BE REPRODUCED OR TRANSMITTED IN ANY FORM OR BY ANY MEANS, ELECTRONIC OR MECHANICAL, INCLUDING PHOTOCOPYING, RECORDING, OR BY ANY INFORMATION STORAGE AND RETRIEVAL SYSTEM, WITHOUT THE WRITTEN PERMISSION OF BOWMAN CONSULTING. © 2020 BOWMAN CONSULTING, LLC. ALL RIGHTS RESERVED.

3 REV. PER NJDEP FIA
2 REV. FOR TOWN SUBMISSION
1 REGULATORY AGENCY SUBMISSION

5/1/21 KK
4/1/21 KK
1/26/21 SAO

REVISION
DATE
CHKD

Bowman
CONSULTING

Phone: 732-665-5500
300 N. Main Street, Suite 272B
Hopewell, NJ 08520
www.bowmanconsulting.com
Email: info@bowmanconsulting.com

Sean A. Delany, N.J. Professional Engineer, Lic. 246E04447100

PLANS ARE FINAL FOR SANITARY SEWER AND WATER MAIN DESIGN
PRELIMINARY & FINAL MAJOR SUBDIVISION AND PRELIMINARY & FINAL SITE PLAN
THE COLLECTION at HOPEWELL
UTILITIES PLAN

SHEET No.
7
OF **E**

BLOCK 66, LOT 3; BLOCK 66, LOTS 32-34 & 35; AND PART OF BLOCK 65, LOT 9
TOWNSHIP OF HOPEWELL, MERCER COUNTY, NEW JERSEY